


MECHANICAL LOUVER - SEE
DETAIL 9/A801 & 10/A801.

ALTERNATE BID HOSE TOWER 130
SEE ROOM FINISH SCHEDULE FOR
FINISH CEILING SYSTEM. PROVIDE
A FINISHED SOFFIT SYSTEM
AROUND ENTIRE HOSE TOWER.




FIRST FLOOR REFLECTED CEILING PLAN

1/8" = 1'-0"

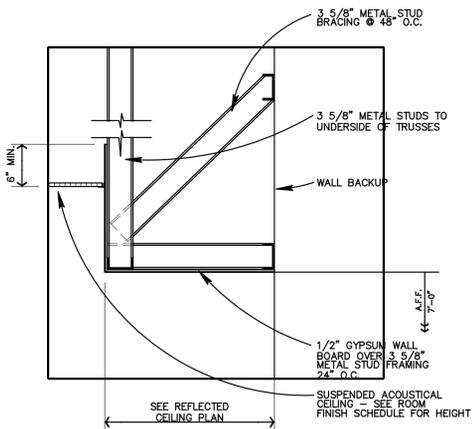

1 TYPICAL SOFFIT DETAIL
A301 1" = 1'-0"

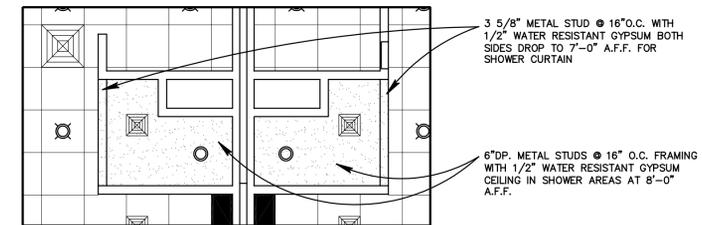

2 SHOWER CEILING FRAMING
A301 1/4" = 1'-0"

SYMBOL SCHEDULE	
	SECTION NUMBER BUILDING SECTION SHEET ON WHICH DRAWN
	DETAIL OR SECTION NUMBER SECTION OR DETAIL SHEET ON WHICH DRAWN
	ELEVATION NUMBER WALL ELEVATION SHEET ON WHICH DRAWN
	ROOM NAME ROOM NUMBER SEE ROOM SCHEDULE
	2' X 2' ACOUSTICAL CEILING TILE (SEE ROOM FINISH SCHEDULE - SHEET A401)
	GYPSUM CEILING (SEE ROOM FINISH SCHEDULE - SHEET A401)
	2' X 4' LIGHT FIXTURE (SEE ELEC. SHEETS)
	1' X 4' LIGHT FIXTURE (SEE ELEC. SHEETS)
	1' X 8' LIGHT FIXTURE (SEE ELEC. SHEETS)
	FLOURESCENT DOWNLIGHTING (SEE ELEC. SHEETS)
	1' X 4' LIGHT FIXTURE (SEE ELEC. SHEETS)

NEW FIRE STATION #2 FOR
GERMANTOWN FIRE DEPARTMENT
EDISON DRIVE
GERMANTOWN, WISCONSIN 53022

05/12/00	KJT
----------	-----

PROJECT NO.
99054A

SHEET NO.
A301

FISCHER-FISCHER-THEIS, INC.
ARCHITECTS • ENGINEERS • PLANNERS
S22 W22660 BROADWAY • WAUKESHA, WISCONSIN 53186-8199
(262) 547-6969 • FAX (262) 547-6960 • E-MAIL: fft@xfpc.com